

THIS DRAWING IS THE PROPERTY OF JRM AND NOT TO BE COPIED OR USED WITHOUT THEIR WRITTEN PERMISSION.



KEY PLAN

DOWNER

CONSOLIDATE REALTOR PVT. LTD.

CONSULTANTS

Architects:
DESIGNPLUS ASSOCIATES SERVICE PVT. LTD.


E-145, Chandra Industrial Estate, Phase 3,
New Delhi

Structural Consultant:
WATTECH CONSULTANTS

C-36, Panchsheel Enclave, Greater Kailash-I,
New Delhi

Plumbing & Fire Consultant:
C.P. VIDYA & ASSOCIATES

212A, United Arcade,
South City-4, Sector-48,

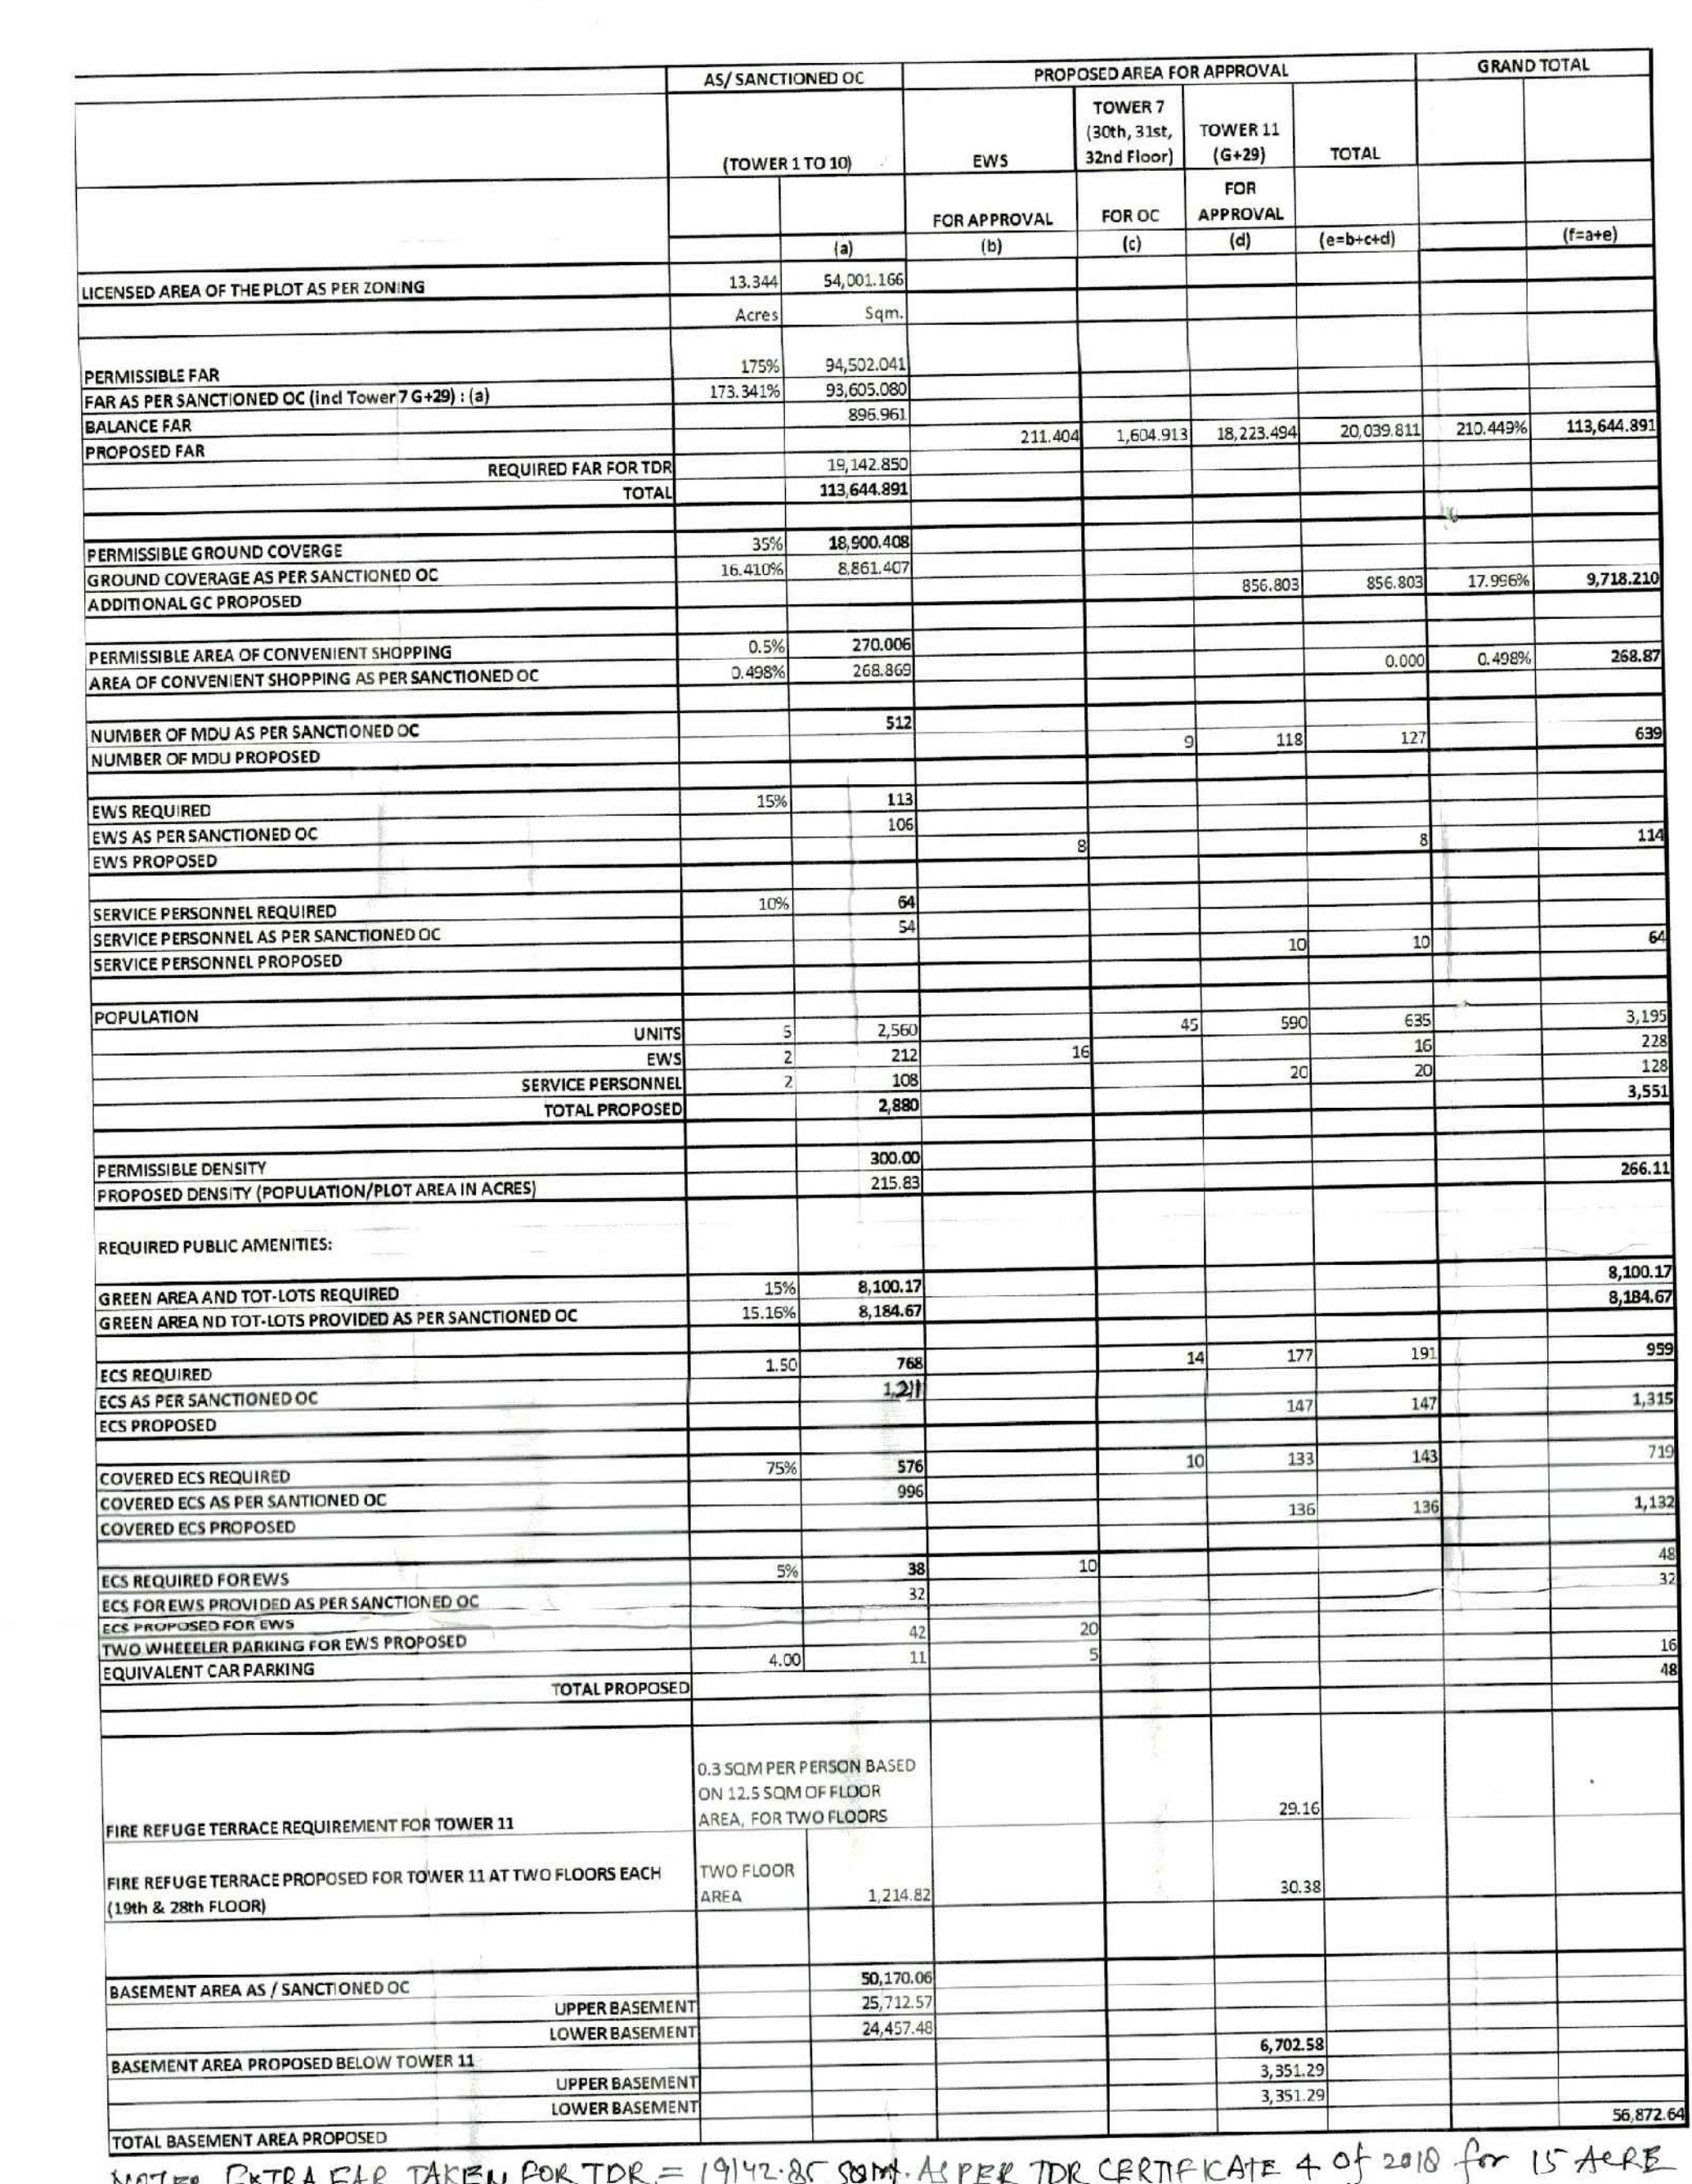

- | | |
|---|--|
|  | PROPOSED BUILDING |
|  | EXISTING BUILDING AS PER
OC SANCTIONED |
|  | TOWER No-7
ALREADY SANCTIONED AND C.C. GRANTED
(FOR 4/11/10 TO 30/11/10) |

	UPPER BASEMENT				3,351.79		
	LOWER BASEMENT						56,872.64
TOTAL BASEMENT AREA PROPOSED							

Structure: Pktd & Cldr Taken for TDR = 1942.88 sqm. As per TDR Certificate 4 of 2010 for 15 Acre

PROJECT NAME	
Proposed Addition of Tower 11 in Group Housing Complex measuring 13.344 Acres (License No. 53 of 2011, Dated 10.06.2011)	
Sect: 68/7, Gurugan Manesar Urban Complex being developed by Conservative Builders Pvt. Ltd.	
DRAWING STATUS	
SUBMISSION DRAWING	
DRAWING TITLE	
TOWER-11 SITE PLAN SEWER LAYOUT	
ARCHITECT'S SIGN	CHECKED BY
 SUBMITTAL QUALITY CHECKED BY DATE: 10/06/2011 BY: [Signature]	
SCALE	NORTH
1:500	
DRAWING NUMBER	REVISION
A-001	